




Stayton Vet  
Pure Energy Group

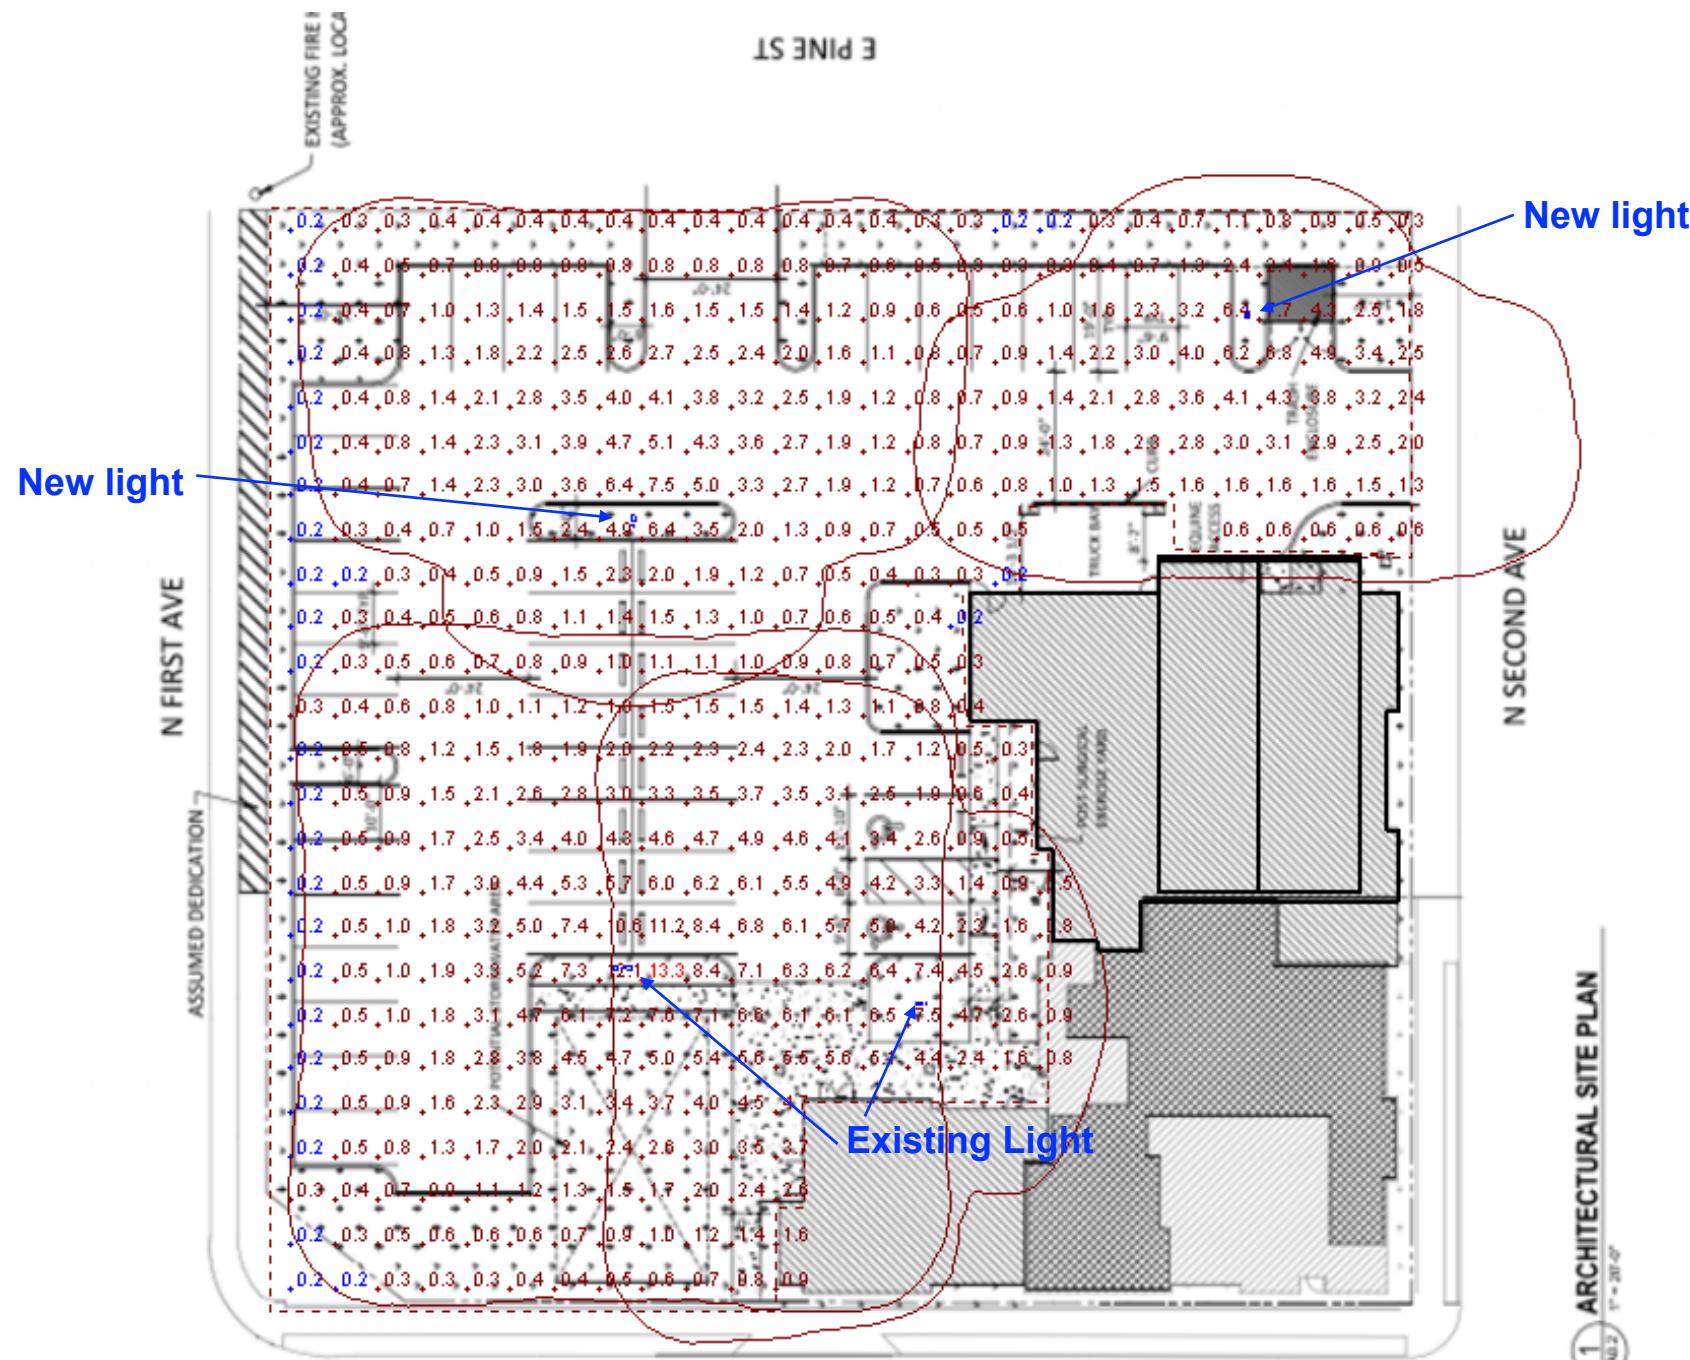

1 ARCHITECTURAL SITE PLAN  
1' = 20'-0"

#### Schedule

Symbol	Label	Image	QTY	Manufacturer	Catalog	Description	Number Lamps	Lamp Output	LLF	Input Power	Polar Plot
□	R4		2	American Electric Lighting	ATB0 P303 R4 4K	Autobahn Small P303 Package Roadway Type IV 4000K/5000K	1	15379	0.95	106	
□	R4H S		1	American Electric Lighting	ATB0 P303 R4 4K/5K HSS	Autobahn Small P303 Package Roadway Type IV 4000K/5000K House side shield	1	12701	0.95	106	
□	R4tw in		1	American Electric Lighting	ATB0 P303 R4 4K	Autobahn Small P303 Package Roadway Type IV 4000K/5000K	1	15379	0.95	212	

#### Statistics

Description	Symbol	Avg	Max	Min	Max/Min	Avg/Min
Calc Zone #3	+	2.1 fc	13.3 fc	0.2 fc	66.5:1	10.5:1



#### Designer

Date  
03/25/2024

Scale  
Not to Scale

Drawing No.

#### Summary